



**HILLSDALE  
TERRACES**

2700 SOUTH EL CAMINO REAL  
SAN MATEO, CA 94403


Job Number: 13090

No.	Issue	Date
1	Planning Pre-Application	11/27/2013
2	Planning Study Session	01/16/2014
3	Planning Formal Application	04/02/2015
4	Response To Plan Check	12/17/2015
5	Response To Plan Check	04/14/2016

Lighting Schedule								
Mark	Item	Qty	Manufac.	Model #	Description	Material Finish	Dimensions	Add'l Notes
L-1	LED LIGHT	-	TMS LIGHTING	QS-CAL	CALVIN PENDANT	MATTE BLACK	16" D X 7 3/4"H	SUITABLE FOR WET LOCATION
L-2	LED LIGHT	-	BEGA	4426P-537	SURFACE WALL - LINEAR W/ WHITE ACRYLIC DIFFUSER	POWDER COATED BLACK	25 5/8" X 7 7/8" X 6 1/4"	SUITABLE FOR WET LOCATION
L-3	LED LIGHT	-	BEGA	8062LED	SHIELDED BOLLARD WITH SYMMETRICAL LIGHT DISTRIBUTION	POWDER COATED BLACK	10 3/8" X 28 1/8" X 5 1/4"	SUITABLE FOR WET LOCATION
L-4	LED LIGHT	-	HESS	LEDIA LL OD 36	RECESSED FRAMELESS LINEAR LED GLASS	ANODIZED ALUMINUM	19 5/8" L X 1 3/8" W	SUITABLE FOR WET LOCATION
L-5	LED LIGHT	-	Q-TRAN LED	IQ-35-50-90-2.6	LED IP67 FLEXIBLE TAPE LIGHT	WARM WHITE	35'L X 1 1/2" W	DIMMABLE W/ MOTION SENSOR
L-6	LED LIGHT	-	BEGA	9499LED	LED POLE TOP LUMINAIRES	POWDER COATED BLACK	17 3/8" L X 2 3/8" H X 10" W	OUTDOOR, 10' POLE
L-7	LED LIGHT	-	PHILIPS	P6R LYTEPROFILE	6" RECESSED ROUND DOWNLIGHT	WHITE	6" Dia X 4 1/2" H	SUITABLE FOR WET LOCATION

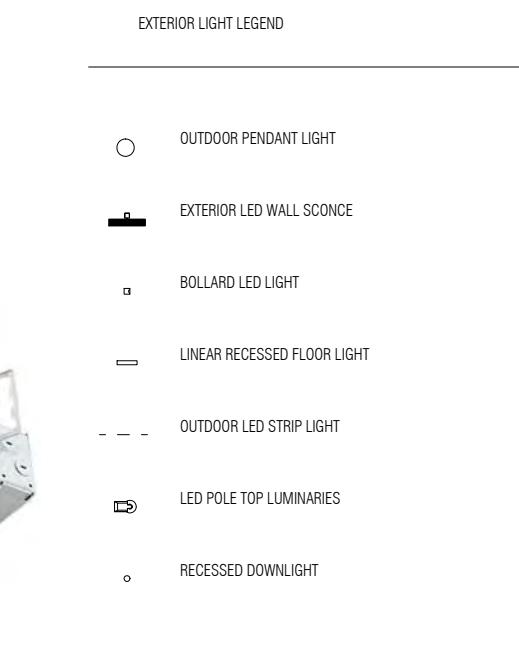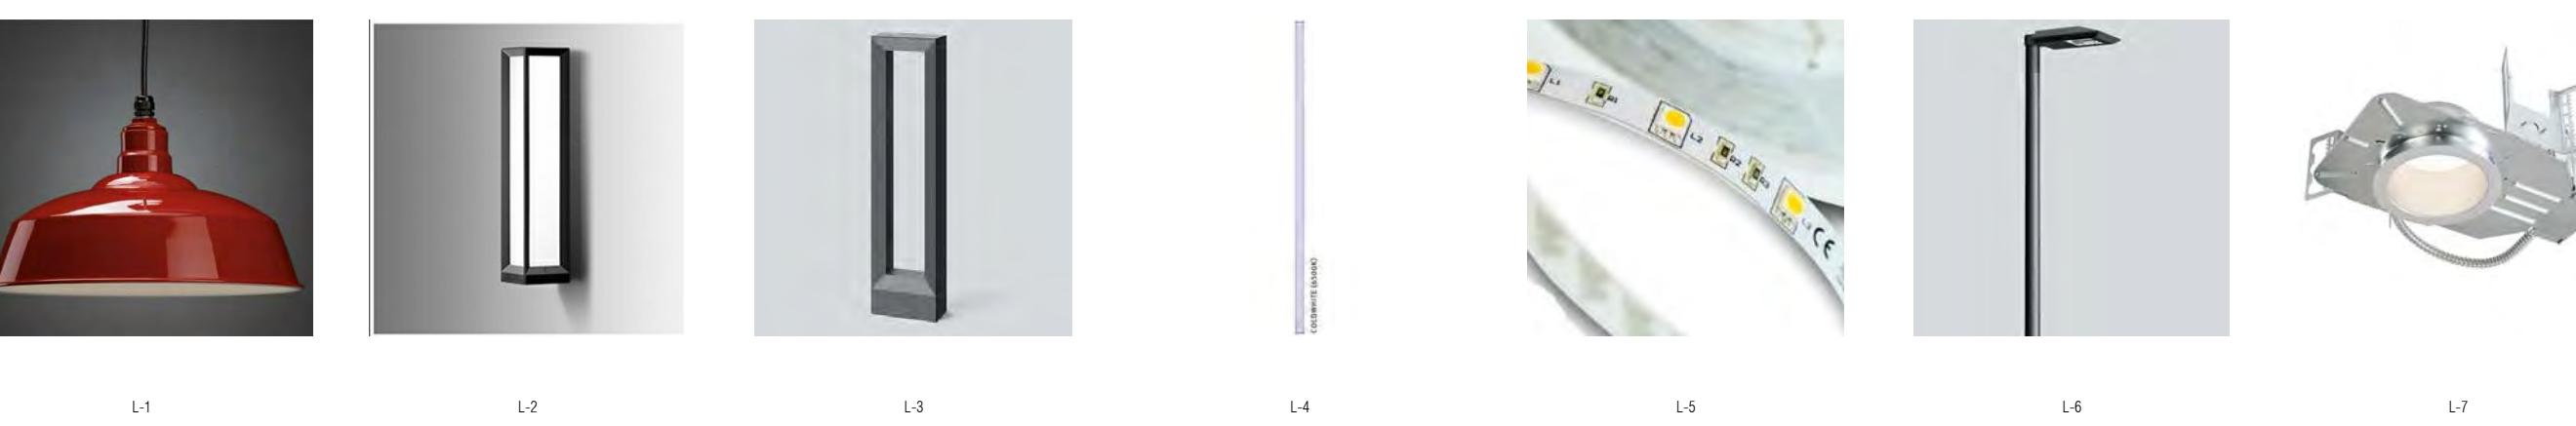

2 LIGHT IMAGES  
3/64" = 1'-0"

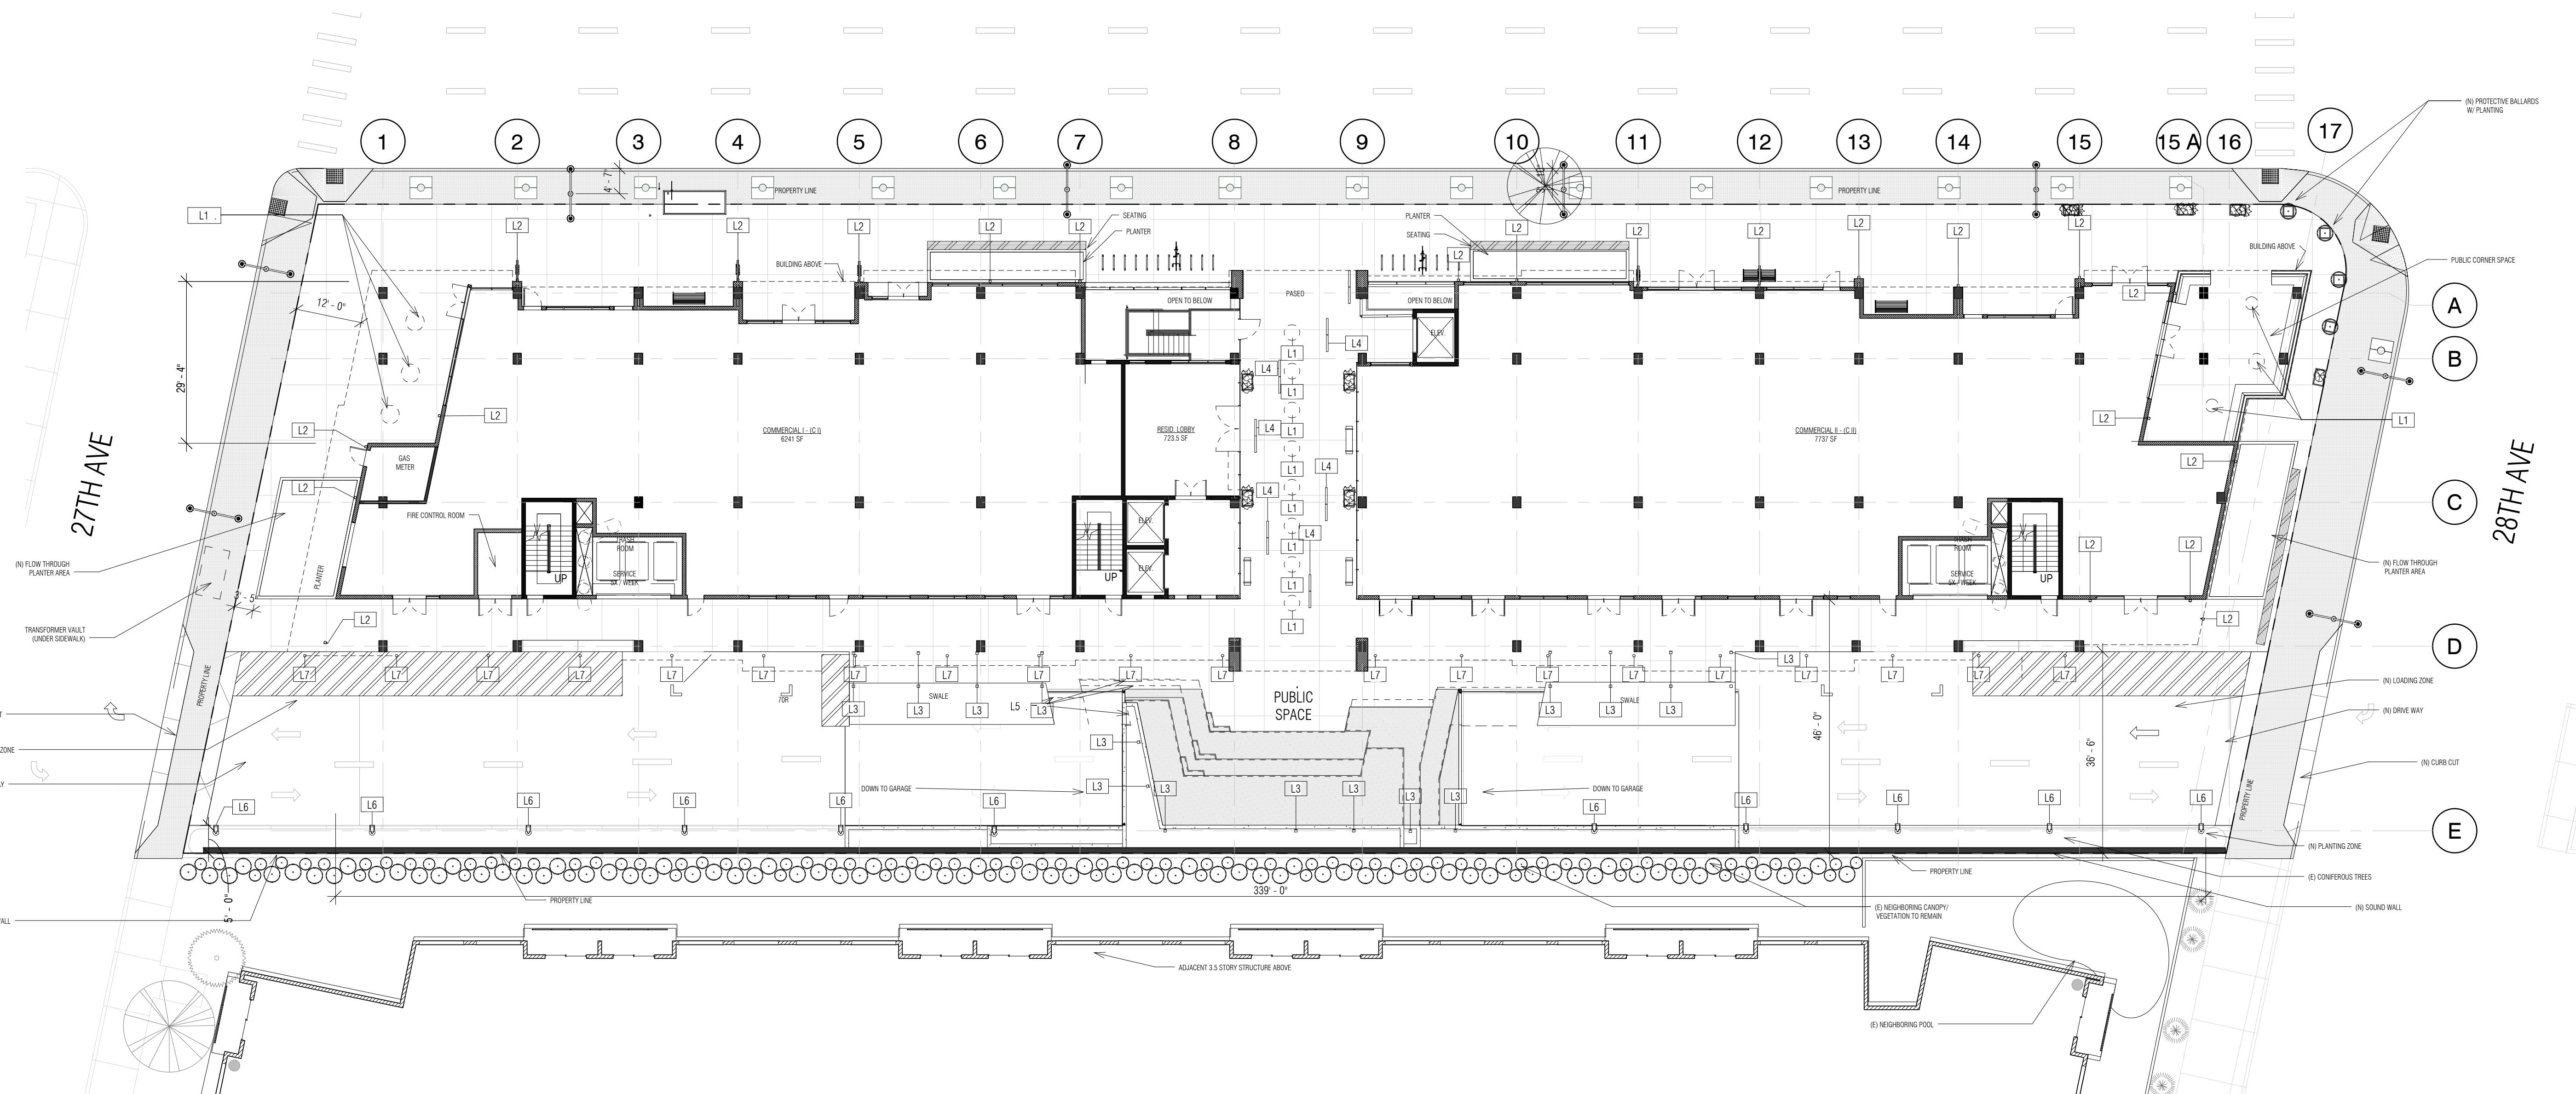

1 Ground Floor - Lighting Plan  
1/16" = 1'-0"

PRINT DATE: 4/28/2016 5:10:21 PM



All drawings and written material appearing herein constitute original and  
unpublished work of Costa Brown Architecture, Inc. and may not be duplicated  
without the prior written consent of  
Costa Brown Architecture, Inc. © 2015.


Date: 04/14/2016

Scale: As indicated

Description:  
**EXTERIOR  
LIGHTING PLAN**

Sheet Number:

**A-8.1**

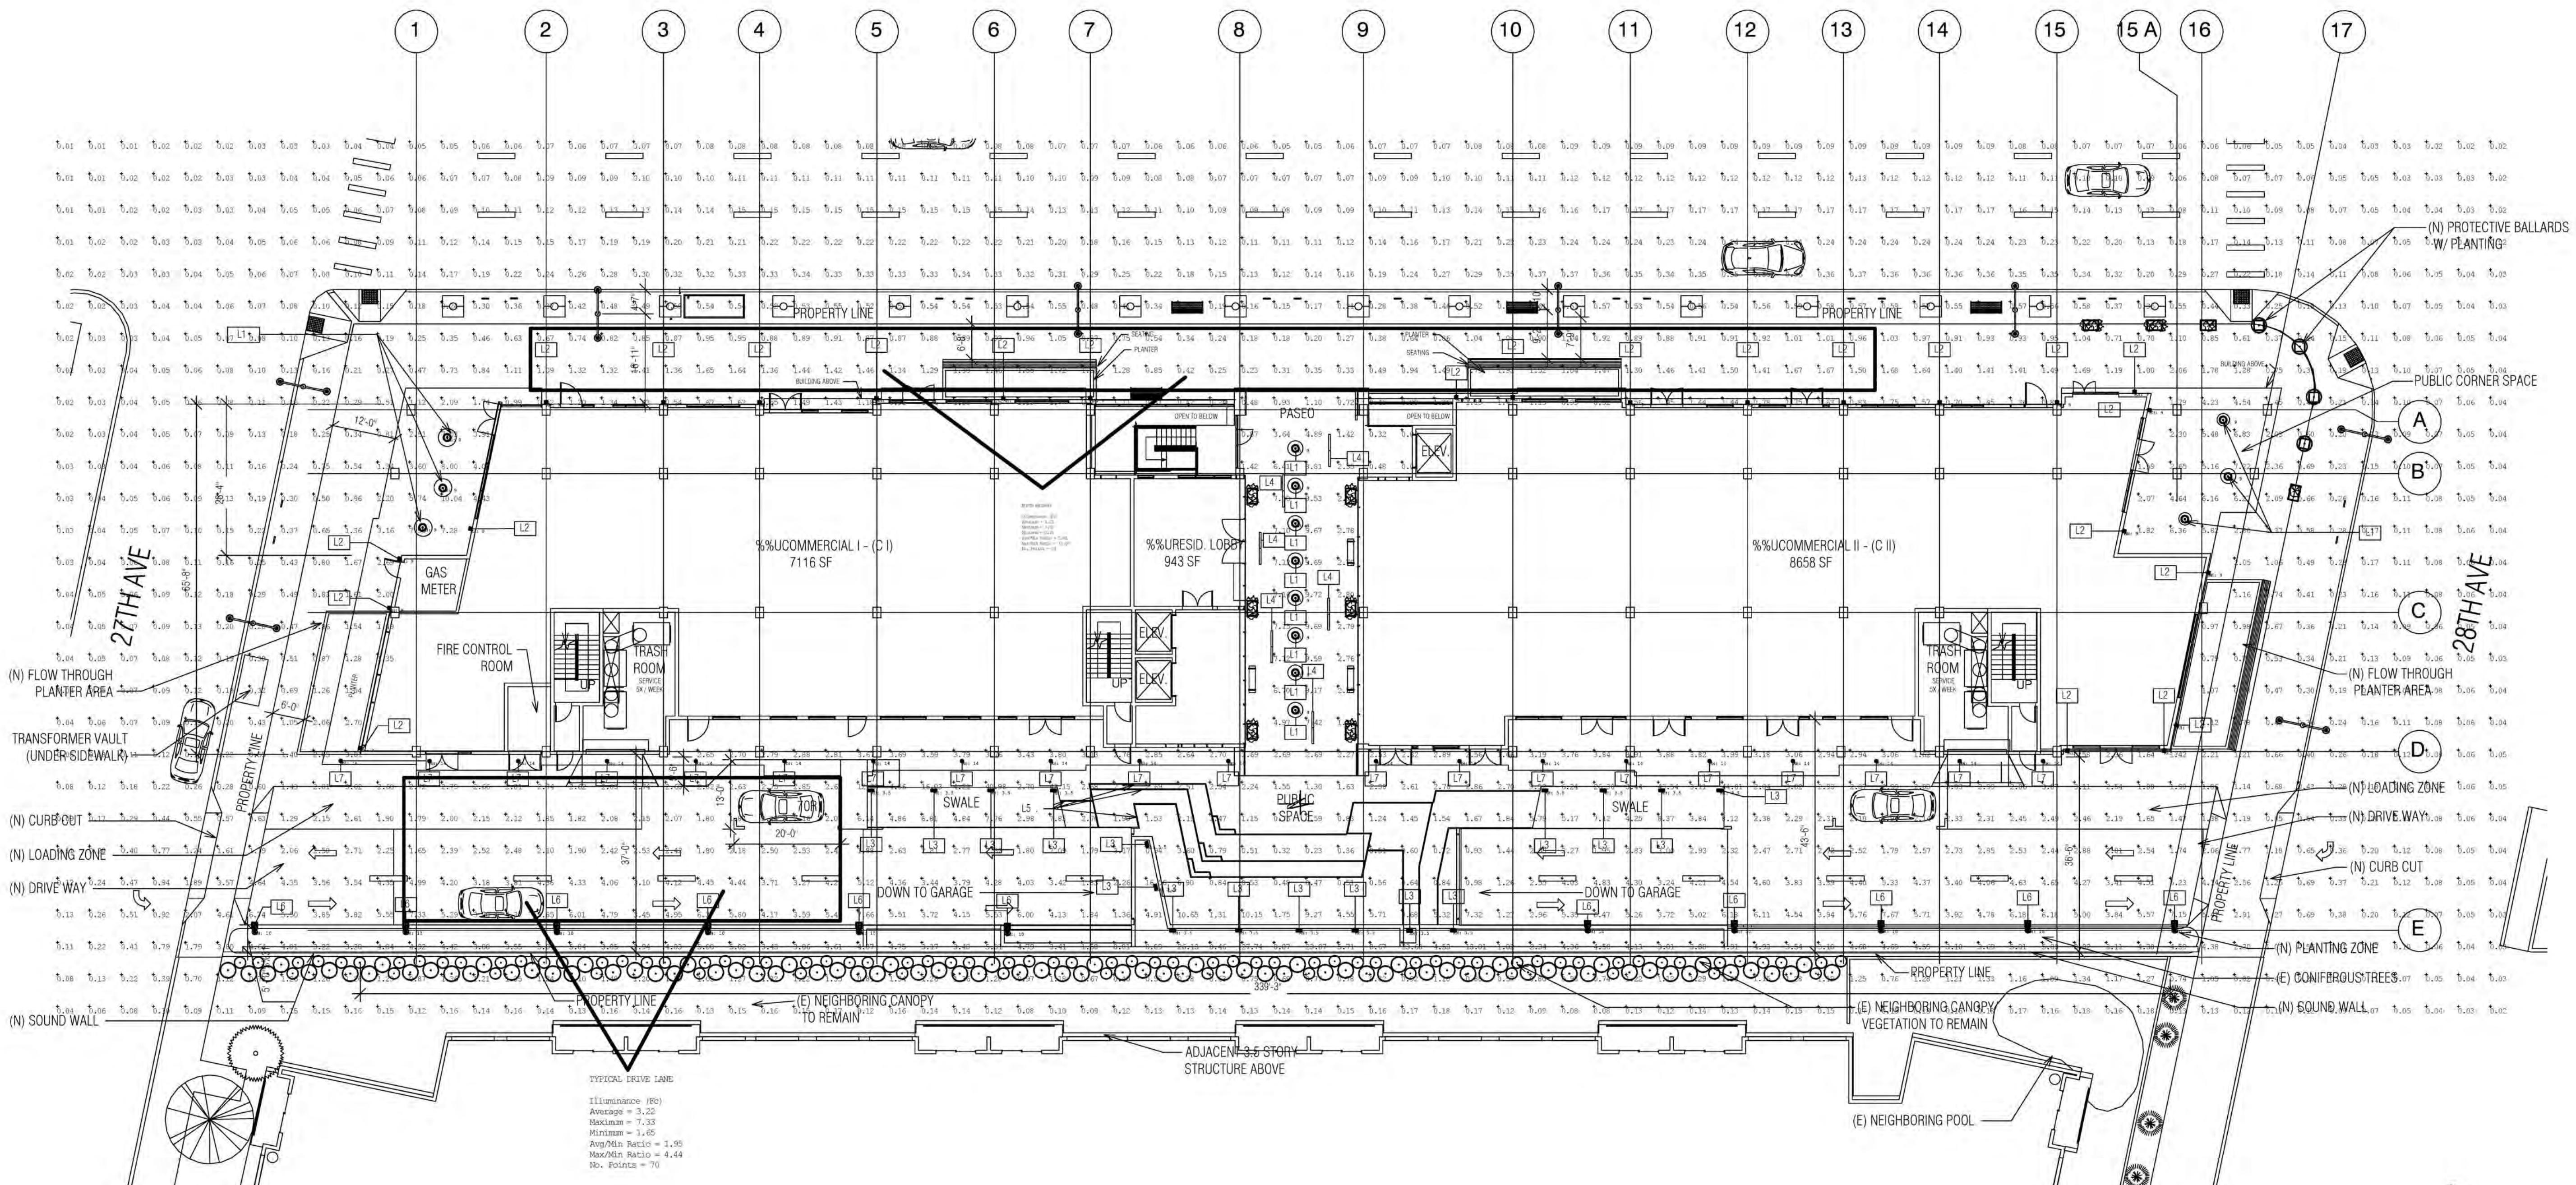

Luminaire Schedule										
Symbol	Qty	Label	Arrangement	Lum. Lumens	LLF	LDD	LLD	BF	Description	Filename
	14	L1	SINGLE	1073	0.900	1.000	0.900	1.000	TMS LIGHTING - CAL-0-16-19LED-C0x-40K-xxx-F15-x-x-x-x-x-x - SUSPENDED	CAL16-19LED.ies
	24	L2	SINGLE	2681	0.900	1.000	0.900	1.000	BEGA - 4426P_537 - WALL MOUNT	4426P_537.ies
	16	L3	SINGLE	1220	0.900	1.000	0.900	1.000	BEGA - 8062LED - BOLLARD	8062LED.ies
	11	L6	SINGLE	3386	0.900	1.000	0.900	1.000	BEGA - 9499LED-TYPE III - POLE MOUNT	9499LED_Type III.ies
	20	L7	SINGLE	1014	0.900	1.000	0.900	1.000	PHILIPS - LIGHTOLIER - P6RD10NZ10UVB-P6RD835VB-P6RDCL - RECESSED	P6RD10NZ10UVB-P6RD835VB-P6RDCL.ies

Calculation Summary									
Label	CalcType	Units	Avg	Max	Min	Avg/Min	Max/Min	# Pts	
NORTH WALKWAY	Illuminance	Fc	1.01	1.92	0.18	5.61	10.67	84	
TYPICAL DRIVE LANE	Illuminance	Fc	3.22	7.33	1.65	1.95	4.44	70	

\*\*\*CALCULATIONS ONLY REPRESENT EQUIPMENT SHOWN IN SCHEDULE. ADDITIONAL CONTRIBUTION FROM EXISTING EQUIPMENT NOT INCLUDED\*\*\*

\* FOR PHOTOMETRY ONLY. SEE A-1.3.1 FOR LATEST GROUND FLOOR PLAN

## \*\*LIGHTING LAYOUT VERIFICATION\*\*\*

ALL VALUES SHOWN ARE MAINTAINED HORIZONTAL FOOTCANDLES AT GRADE

PHOTOMETRIC DATA USED AS INPUT FOR THESE CALCULATIONS  
IS BASED ON ESTABLISHED IES PROCEDURES AND PUBLISHED  
LAMP, RATINGS, FIELD PERFORMANCE WILL DEPEND ON ACTUAL  
LAMP, BALLAST, ELECTRICAL, AND SITE CHARACTERISTICS.

Calculations have been performed according to IES standards and good practice. Some differences between measured values and calculated results may occur due to tolerances in calculation methods, testing procedures, component performance, measurement techniques and field conditions such as voltage and temperature variations. Input data used to generate the attached calculations such as room dimensions, reflectances, furniture and architectural elements significantly affect the lighting calculations. If the real environment conditions do not match the input data, differences will occur between measured values and calculated values.



Associated Lighting Representatives, Inc.

REPORT FOR: COSTA BROWN ARCHITECTURE; MARK ZANNAD  
BY: APPLICATIONS ENGINEERING; DENNIS L. LAVANWAY  
SALES REPRESENTATIVE: ALR; TIM HALEY

AGI32 VERSION 16.4  
AGI (C) 1999-2015 LIGHTING ANALYSTS, INC.  
10268 W. CENTENNIAL RD, SUITE 202  
LITTLETON, CO 80127

PROJECT DESCRIPTION

A 8.2

South El Camino Real Site Furnishing Schedule								
Mark	Item	Qty	Manufac.	Model #	Description	Material Finish	Dimensions (l X w X h)	Add'l Notes
SF-1	TRASH CAN	6	VICTOR STANLEY INC	IRONSITES SERIES, S-424	36 GALLON CAPACITY, SURFACE MOUNTED	BLACK, POWDER COAT	2'-6"X2'-11"	
SF-2	TREE GRATE	16	URBAN ACCESSORIES	OT-TITLE 24		POWDER COAT RAL 6004 (BLACK)	4' X 4'	CUSTOMIZED TO PROVIDE TWO HOLES FOR BUBBLER ACCESS
SF-3	PLANTER	3	WABASH VALLEY			CERAMIC	2' X 3'	
SF-5	PLANTER	2	WABASH VALLEY			SLAT PATTERN, BLACK POWDER COAT	24" X 24" X 18"	
SF-7	BIKE RACK	14	WELLE	CIRCULAR RACK, INGROUND		STAINLESS STEEL	36" X 6" X 2-8"	
SF-8	BENCH	4	WABASH VALLEY	ESTATE SERIES		SLAT PATTERN, BLACK POWDER COAT	2'-2 3/4" X 6'-2 3/4" X 35"	



# Costa Brown Architecture


1620 Montgomery Street, Suite 300  
San Francisco, CA 94111  
Tel: 415 986 0101

# HILLSDALE TERRACES

2700 SOUTH EL CAMINO REAL  
SAN MATEO, CA 94403

Job Number: 13090

No.	Issue	Date
1	Planning Pre-Application	11/27/2013
2	Planning Study Session	01/16/2014
3	Planning Formal Application	04/02/2015
4	Response To Plan Check	12/17/2015
5	Response To Plan Check	04/14/2016

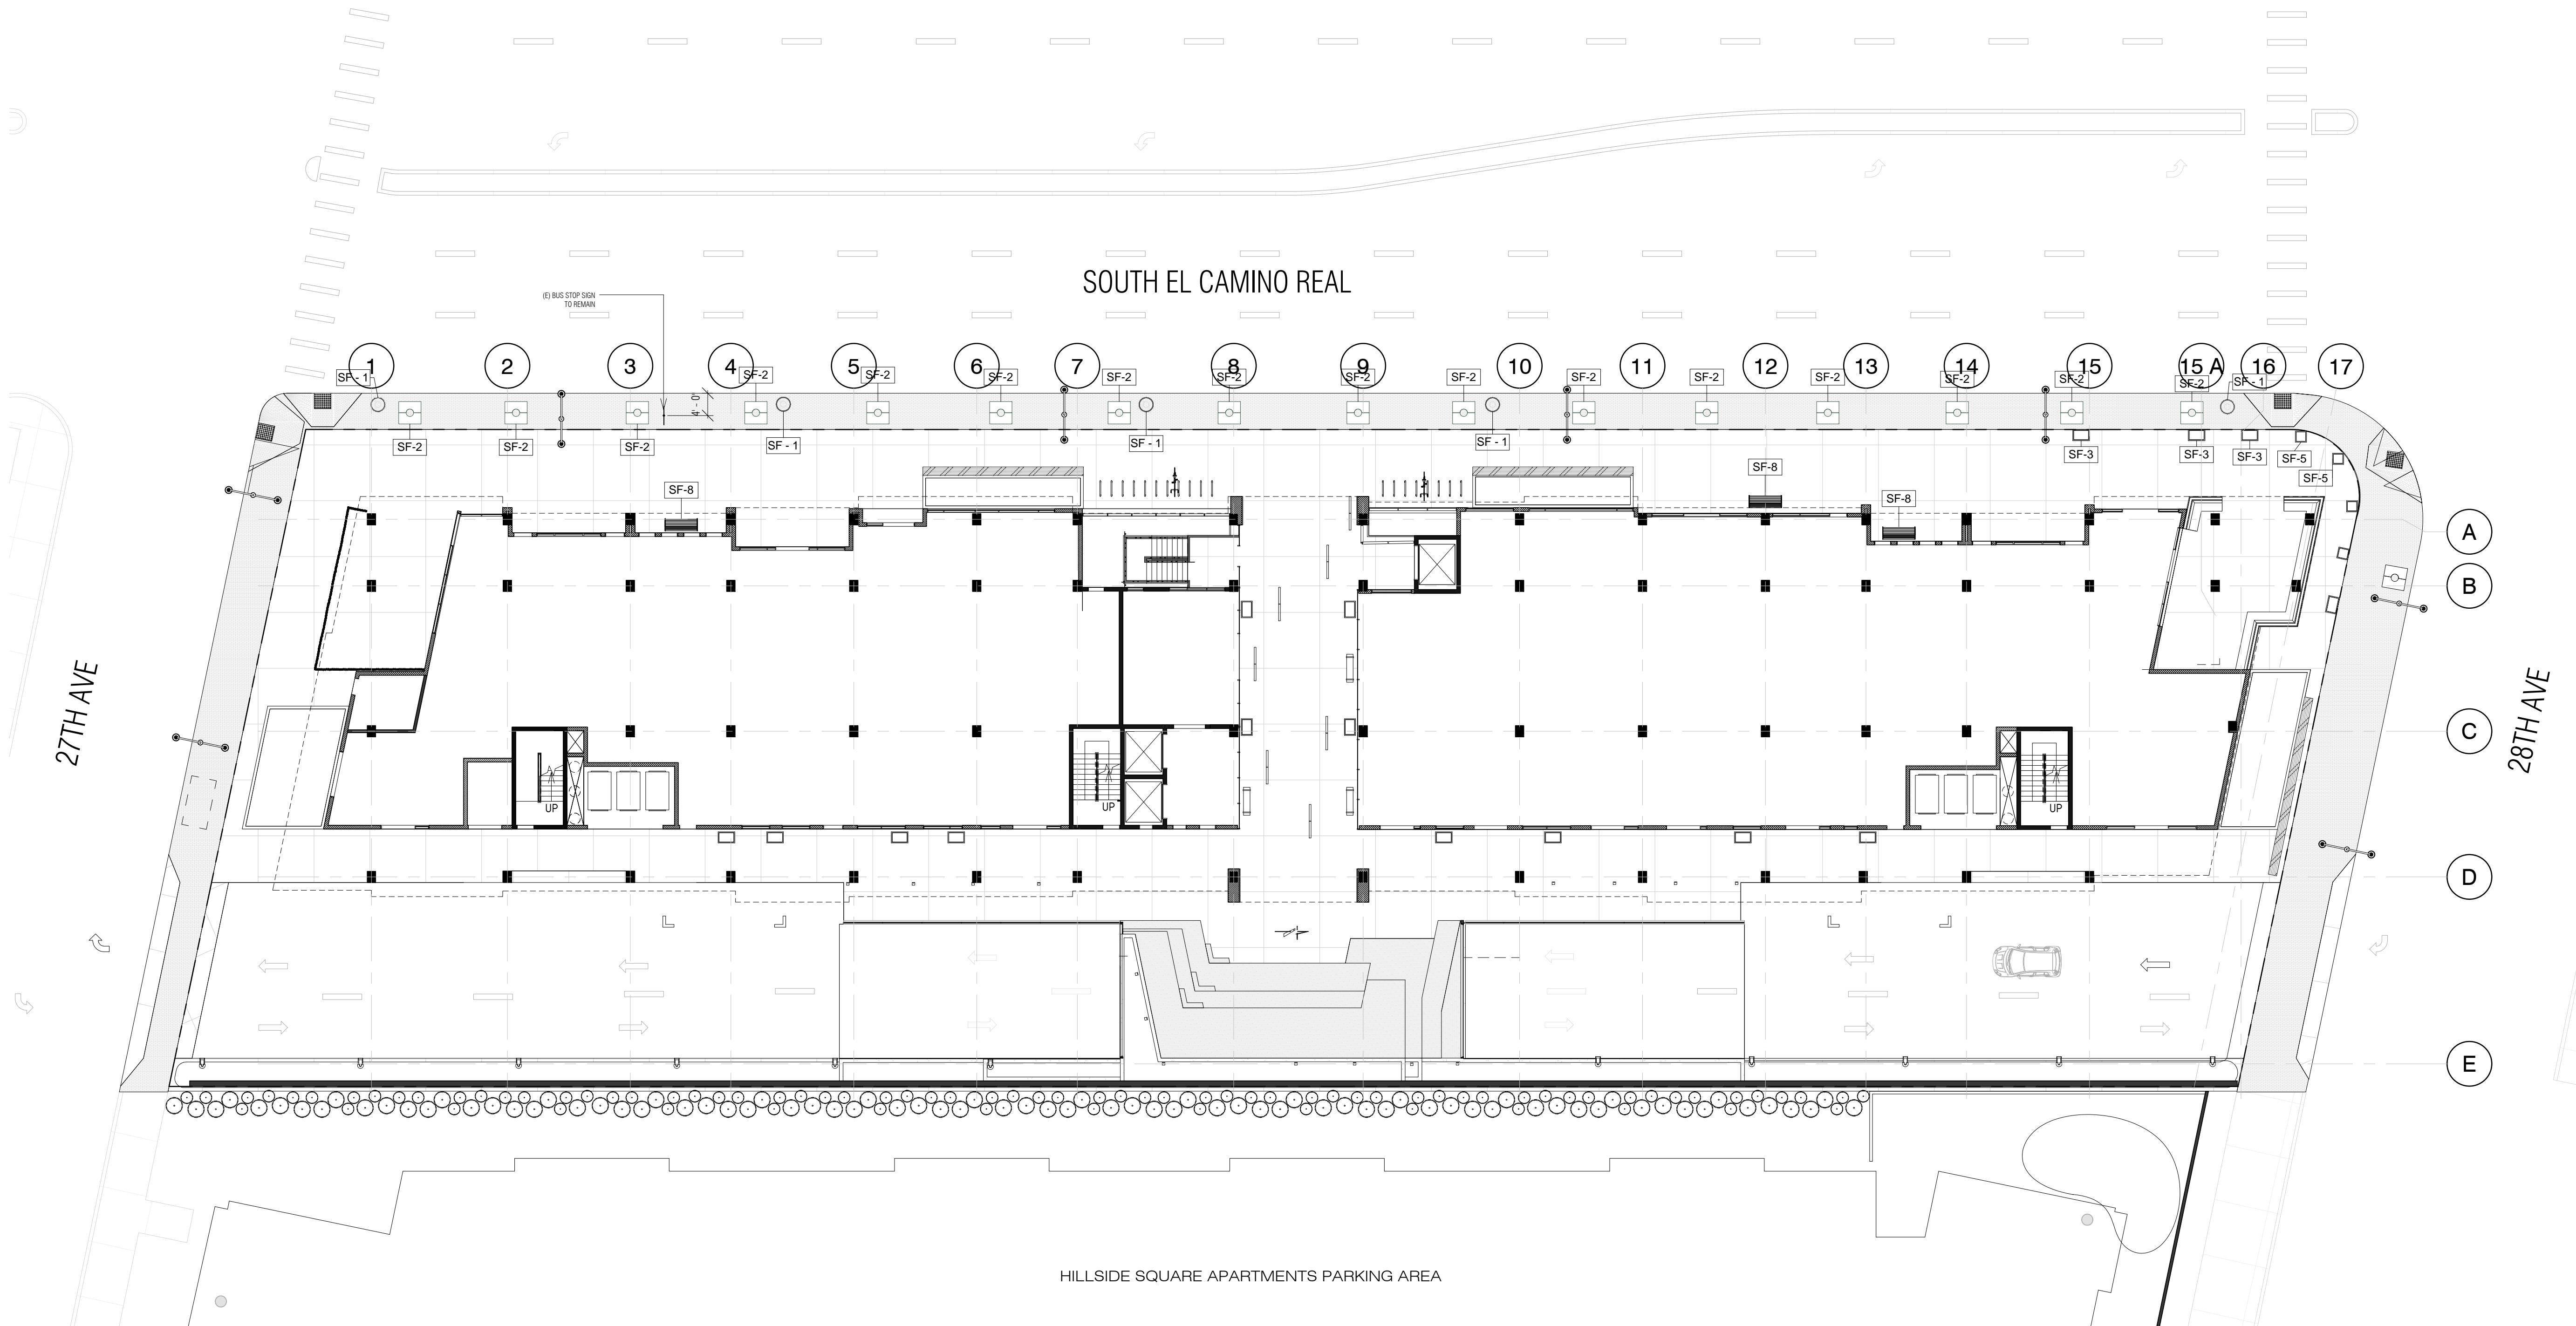

HILL SIDE SQUARE APARTMENTS PARKING AREA

## 1 Ground Floor - Hardscape Plan

All drawings and written material appearing herein constitute original and unpublished work of Costa Brown Architecture, Inc. and may not be duplicated without the prior written consent of  
Costa Brown Architecture, Inc. © 2015

---

Date: 04/14/2016

---

Date: 04/14/2010

Scale. 1/16" = 1'-0"

---

## Description.

EUROPA 10

## FURNIS

# Hardscape Plan

Street Number:


Part Number:

**HILLSDALE  
TERRACES**

2700 SOUTH EL CAMINO REAL  
SAN MATEO, CA 94403

Job Number: 13090

No.	Issue	Date
1	Planning Pre-Application	11/27/2013
2	Planning Study Session	01/16/2014
3	Planning Formal Application	04/02/2015
4	Response To Plan Check	12/17/2015
5	Response To Plan Check	04/14/2016

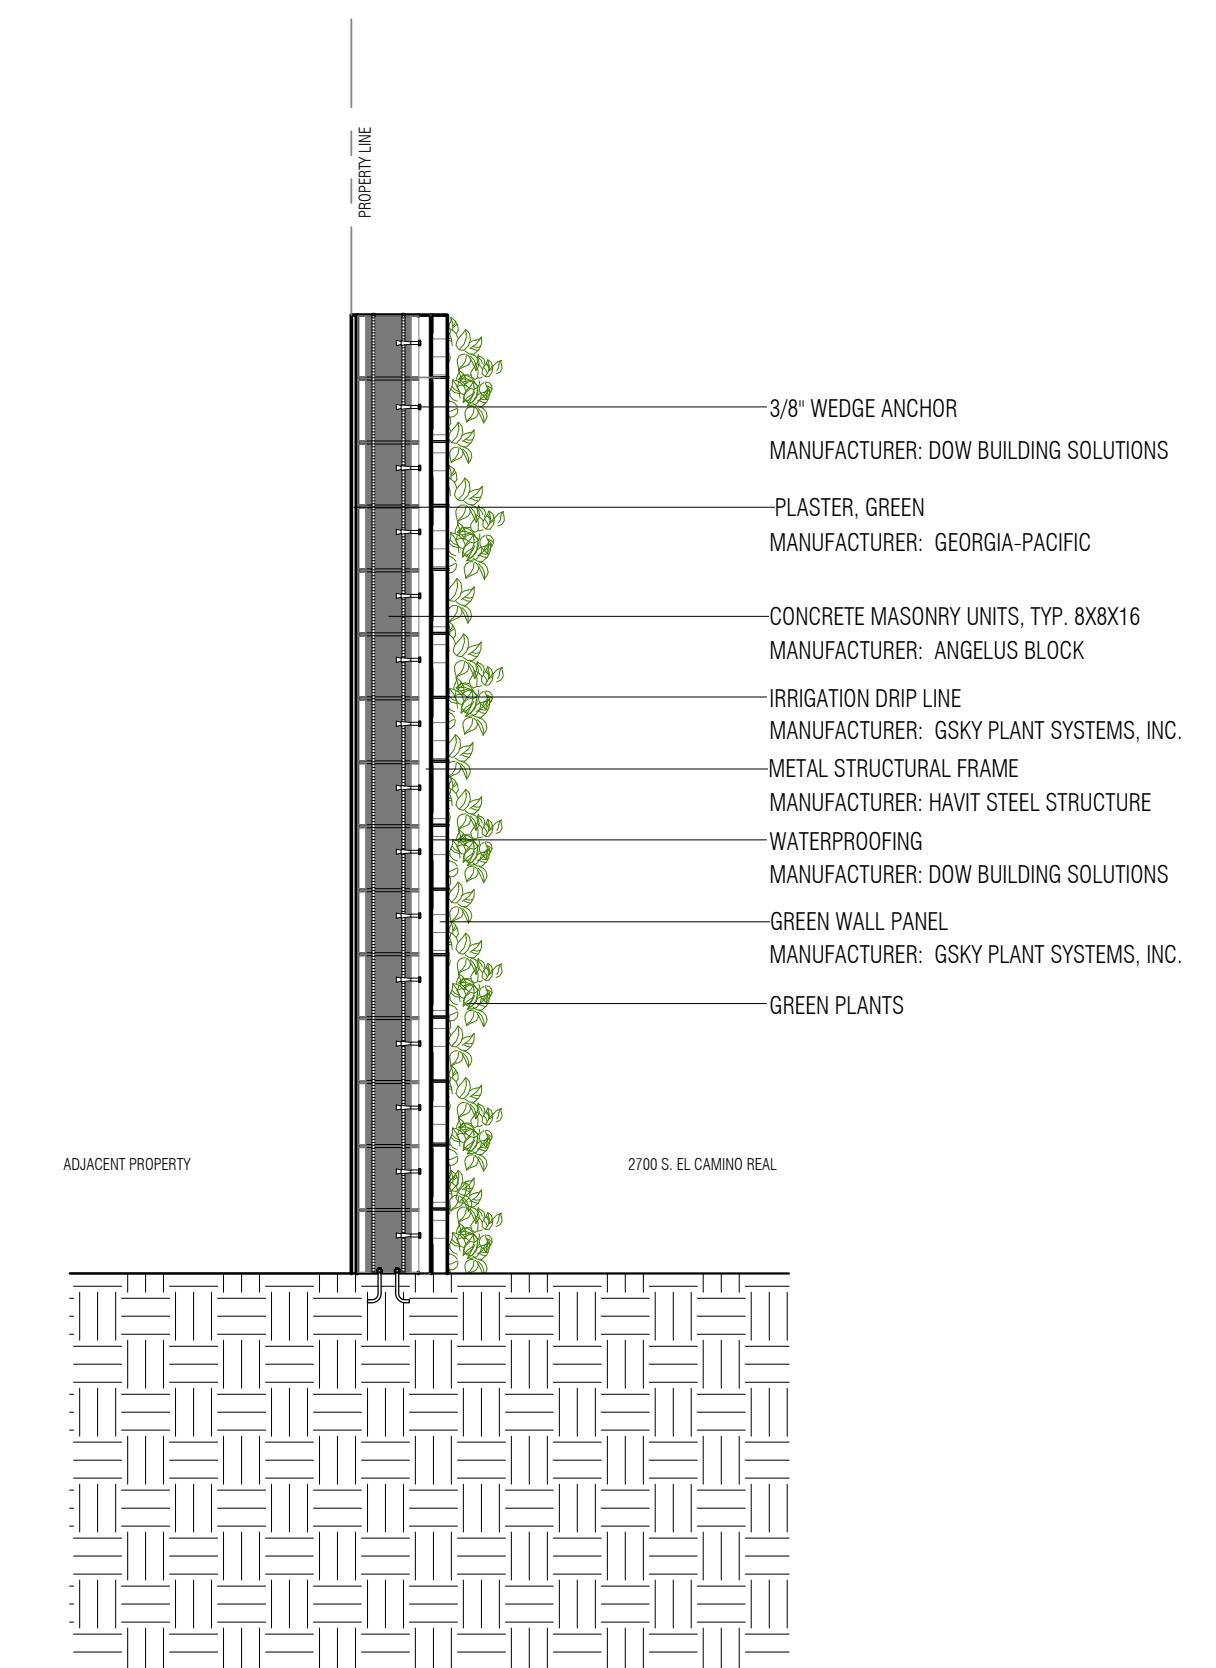

2 CMU Wall Section  
1/2" = 1'-0"

PRINT DATE: 4/28/2016 5:12:55 PM



All drawings and written material appearing herein constitute original and unpublished work of Costa Brown Architecture, Inc. and may not be duplicated without the prior written consent of Costa Brown Architecture, Inc. © 2015.


Date: 04/14/2016

Scale: As indicated

Description:

WALL  
ELEVATION AND  
SECTION ON SITE  
BOUNDARY  
Sheet Number:




A-8.4

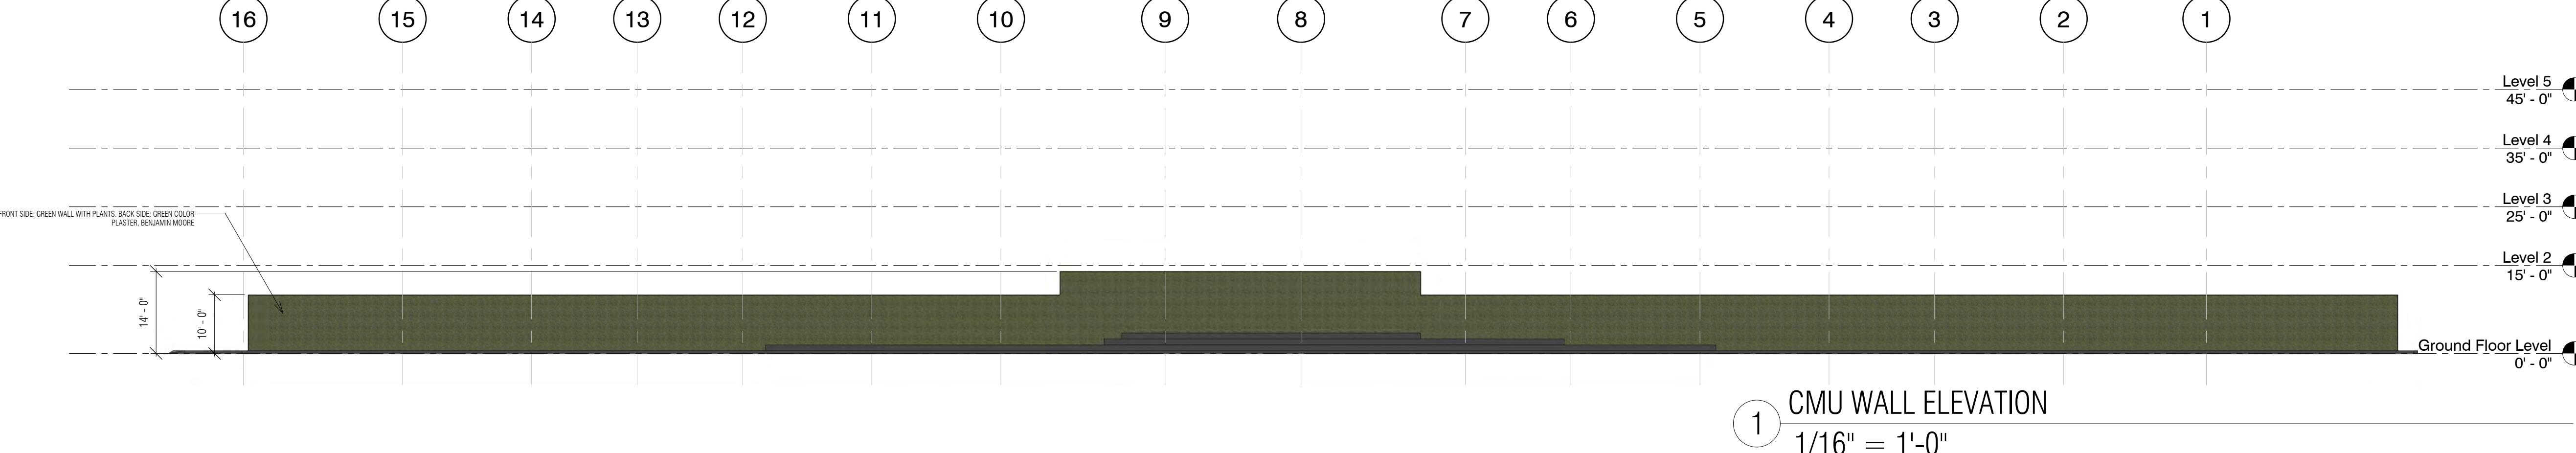

**HILLSDALE  
TERRACES**  
2700 SOUTH EL CAMINO REAL  
SAN MATEO, CA 94403

Job Number: 13090

No.	Issue	Date
1	Planning Pre-Application	11/27/2013
2	Planning Study Session	01/16/2014
3	Planning Formal Application	04/02/2015
4	Response To Plan Check	12/17/2015
5	Response To Plan Check	04/14/2016

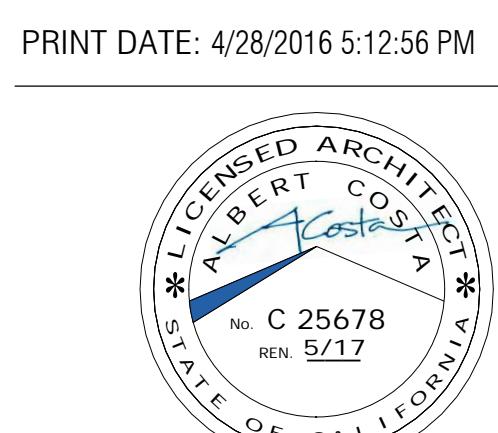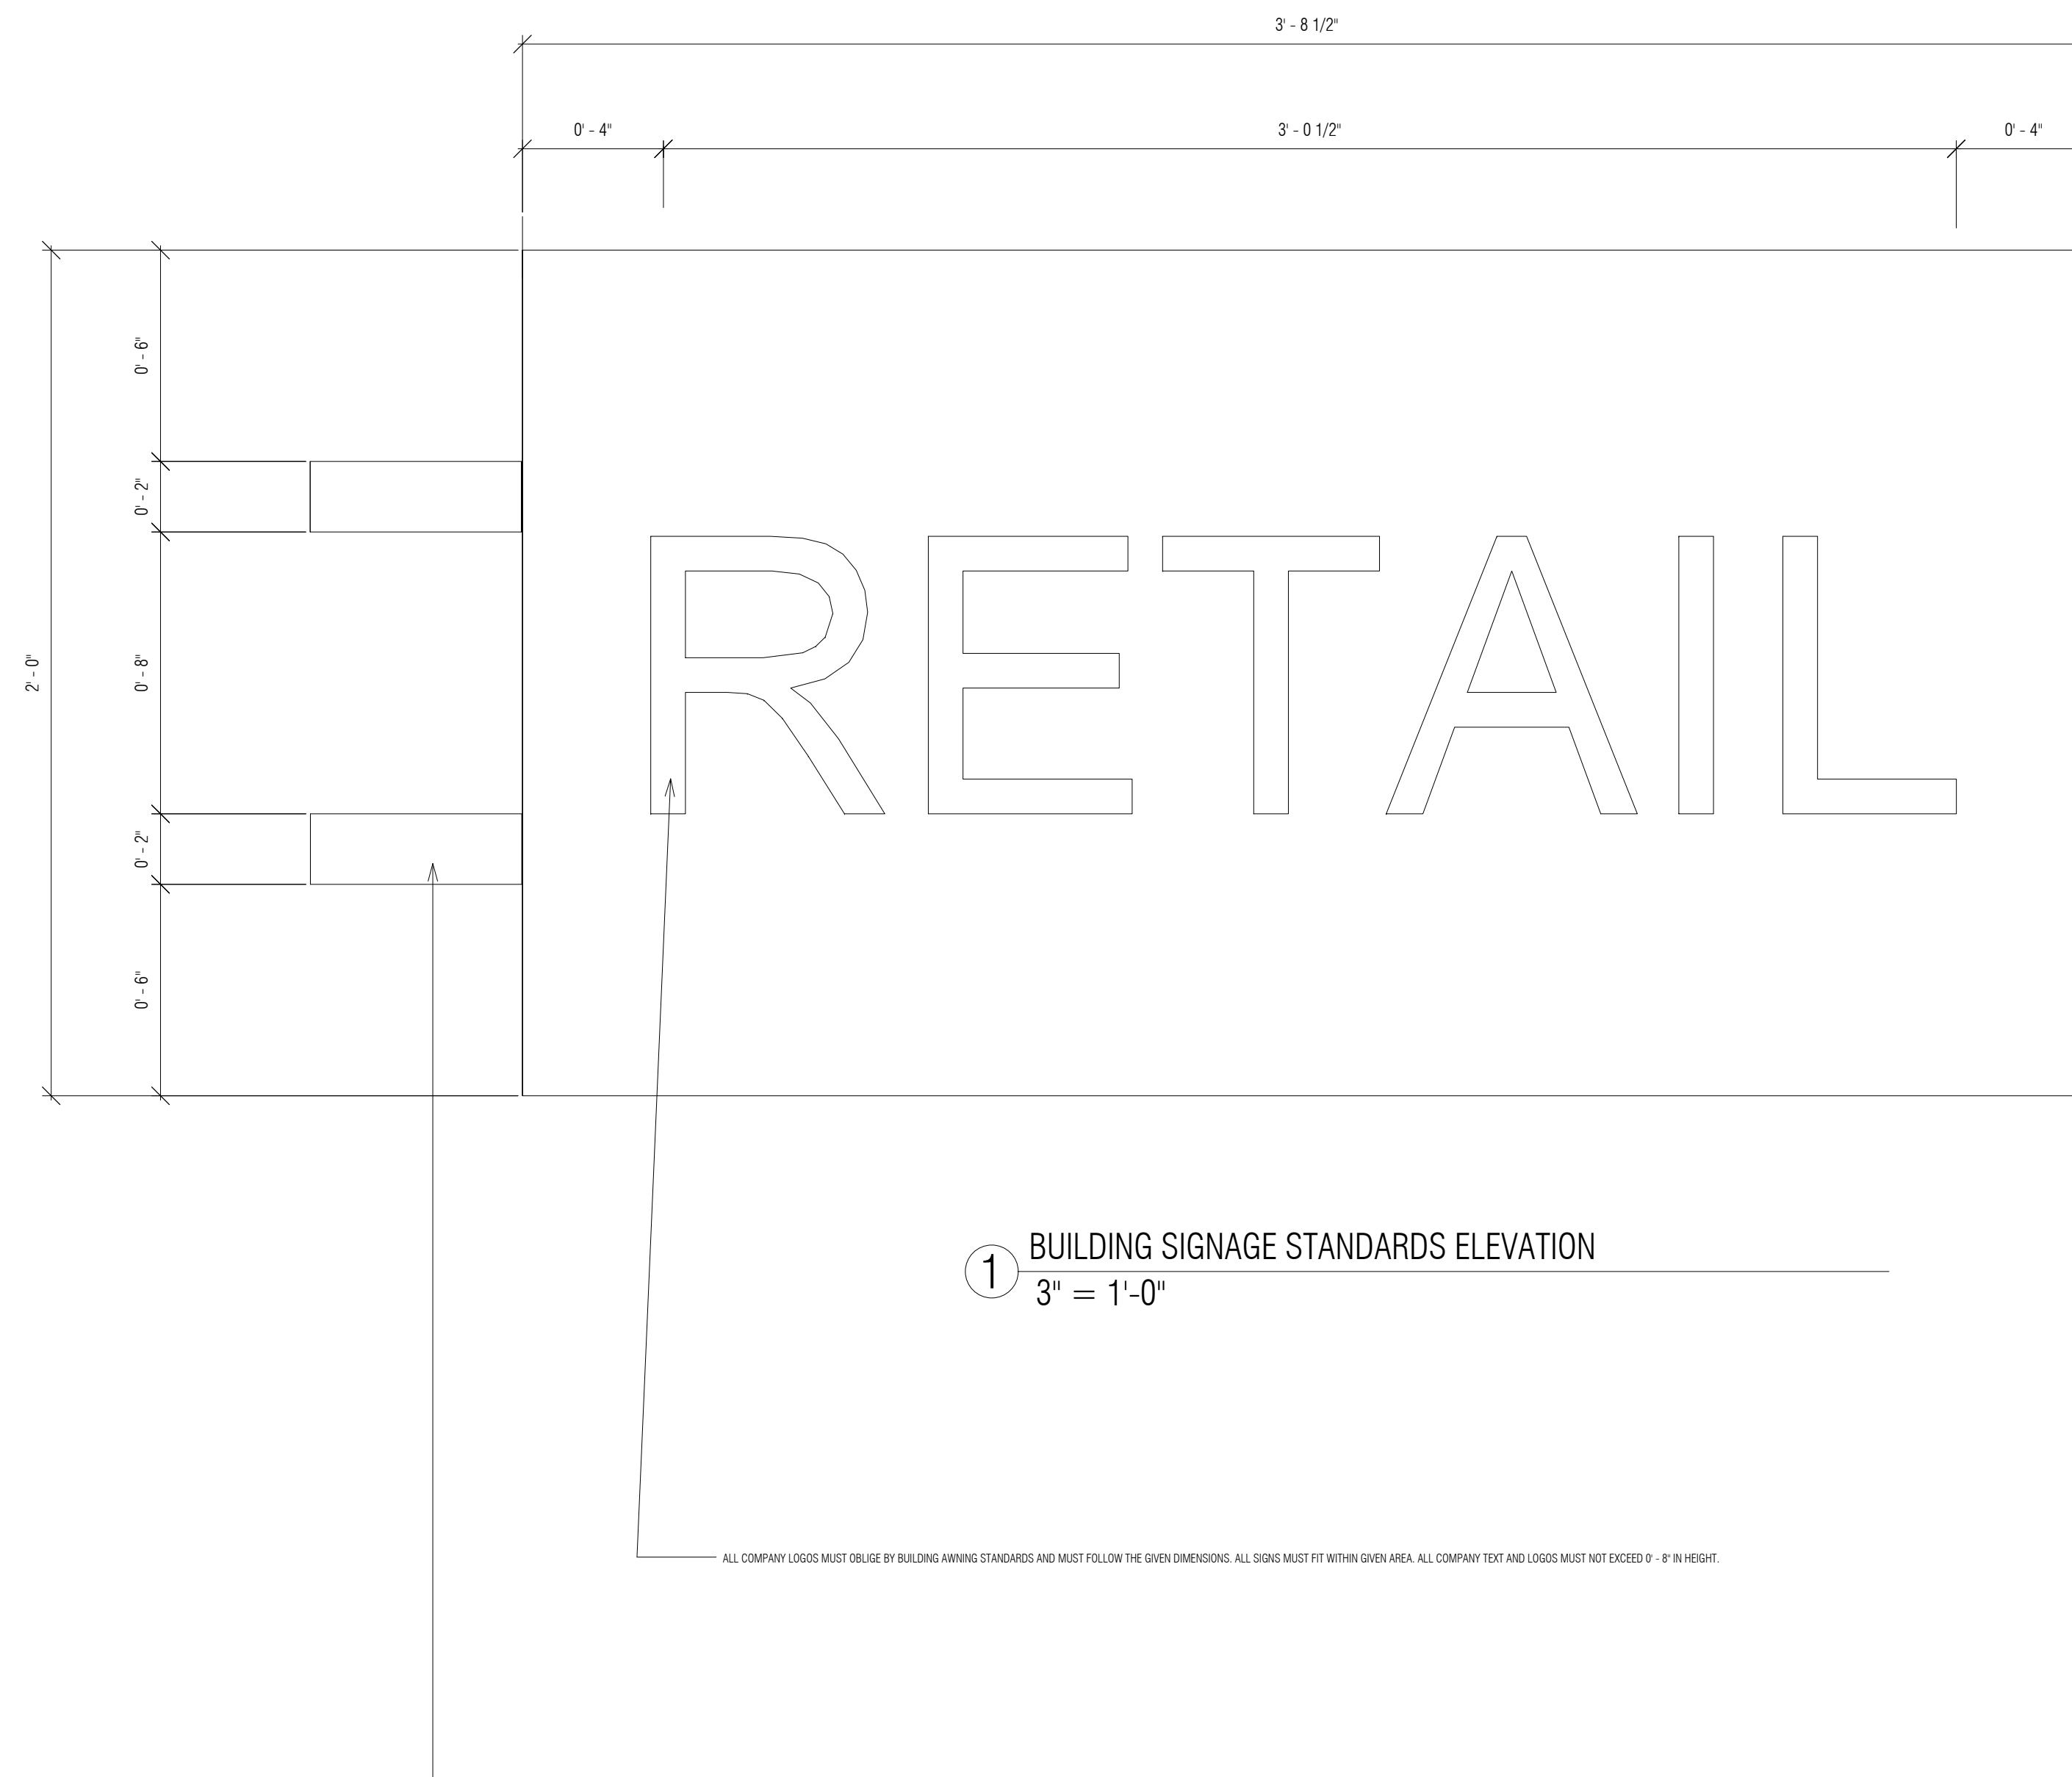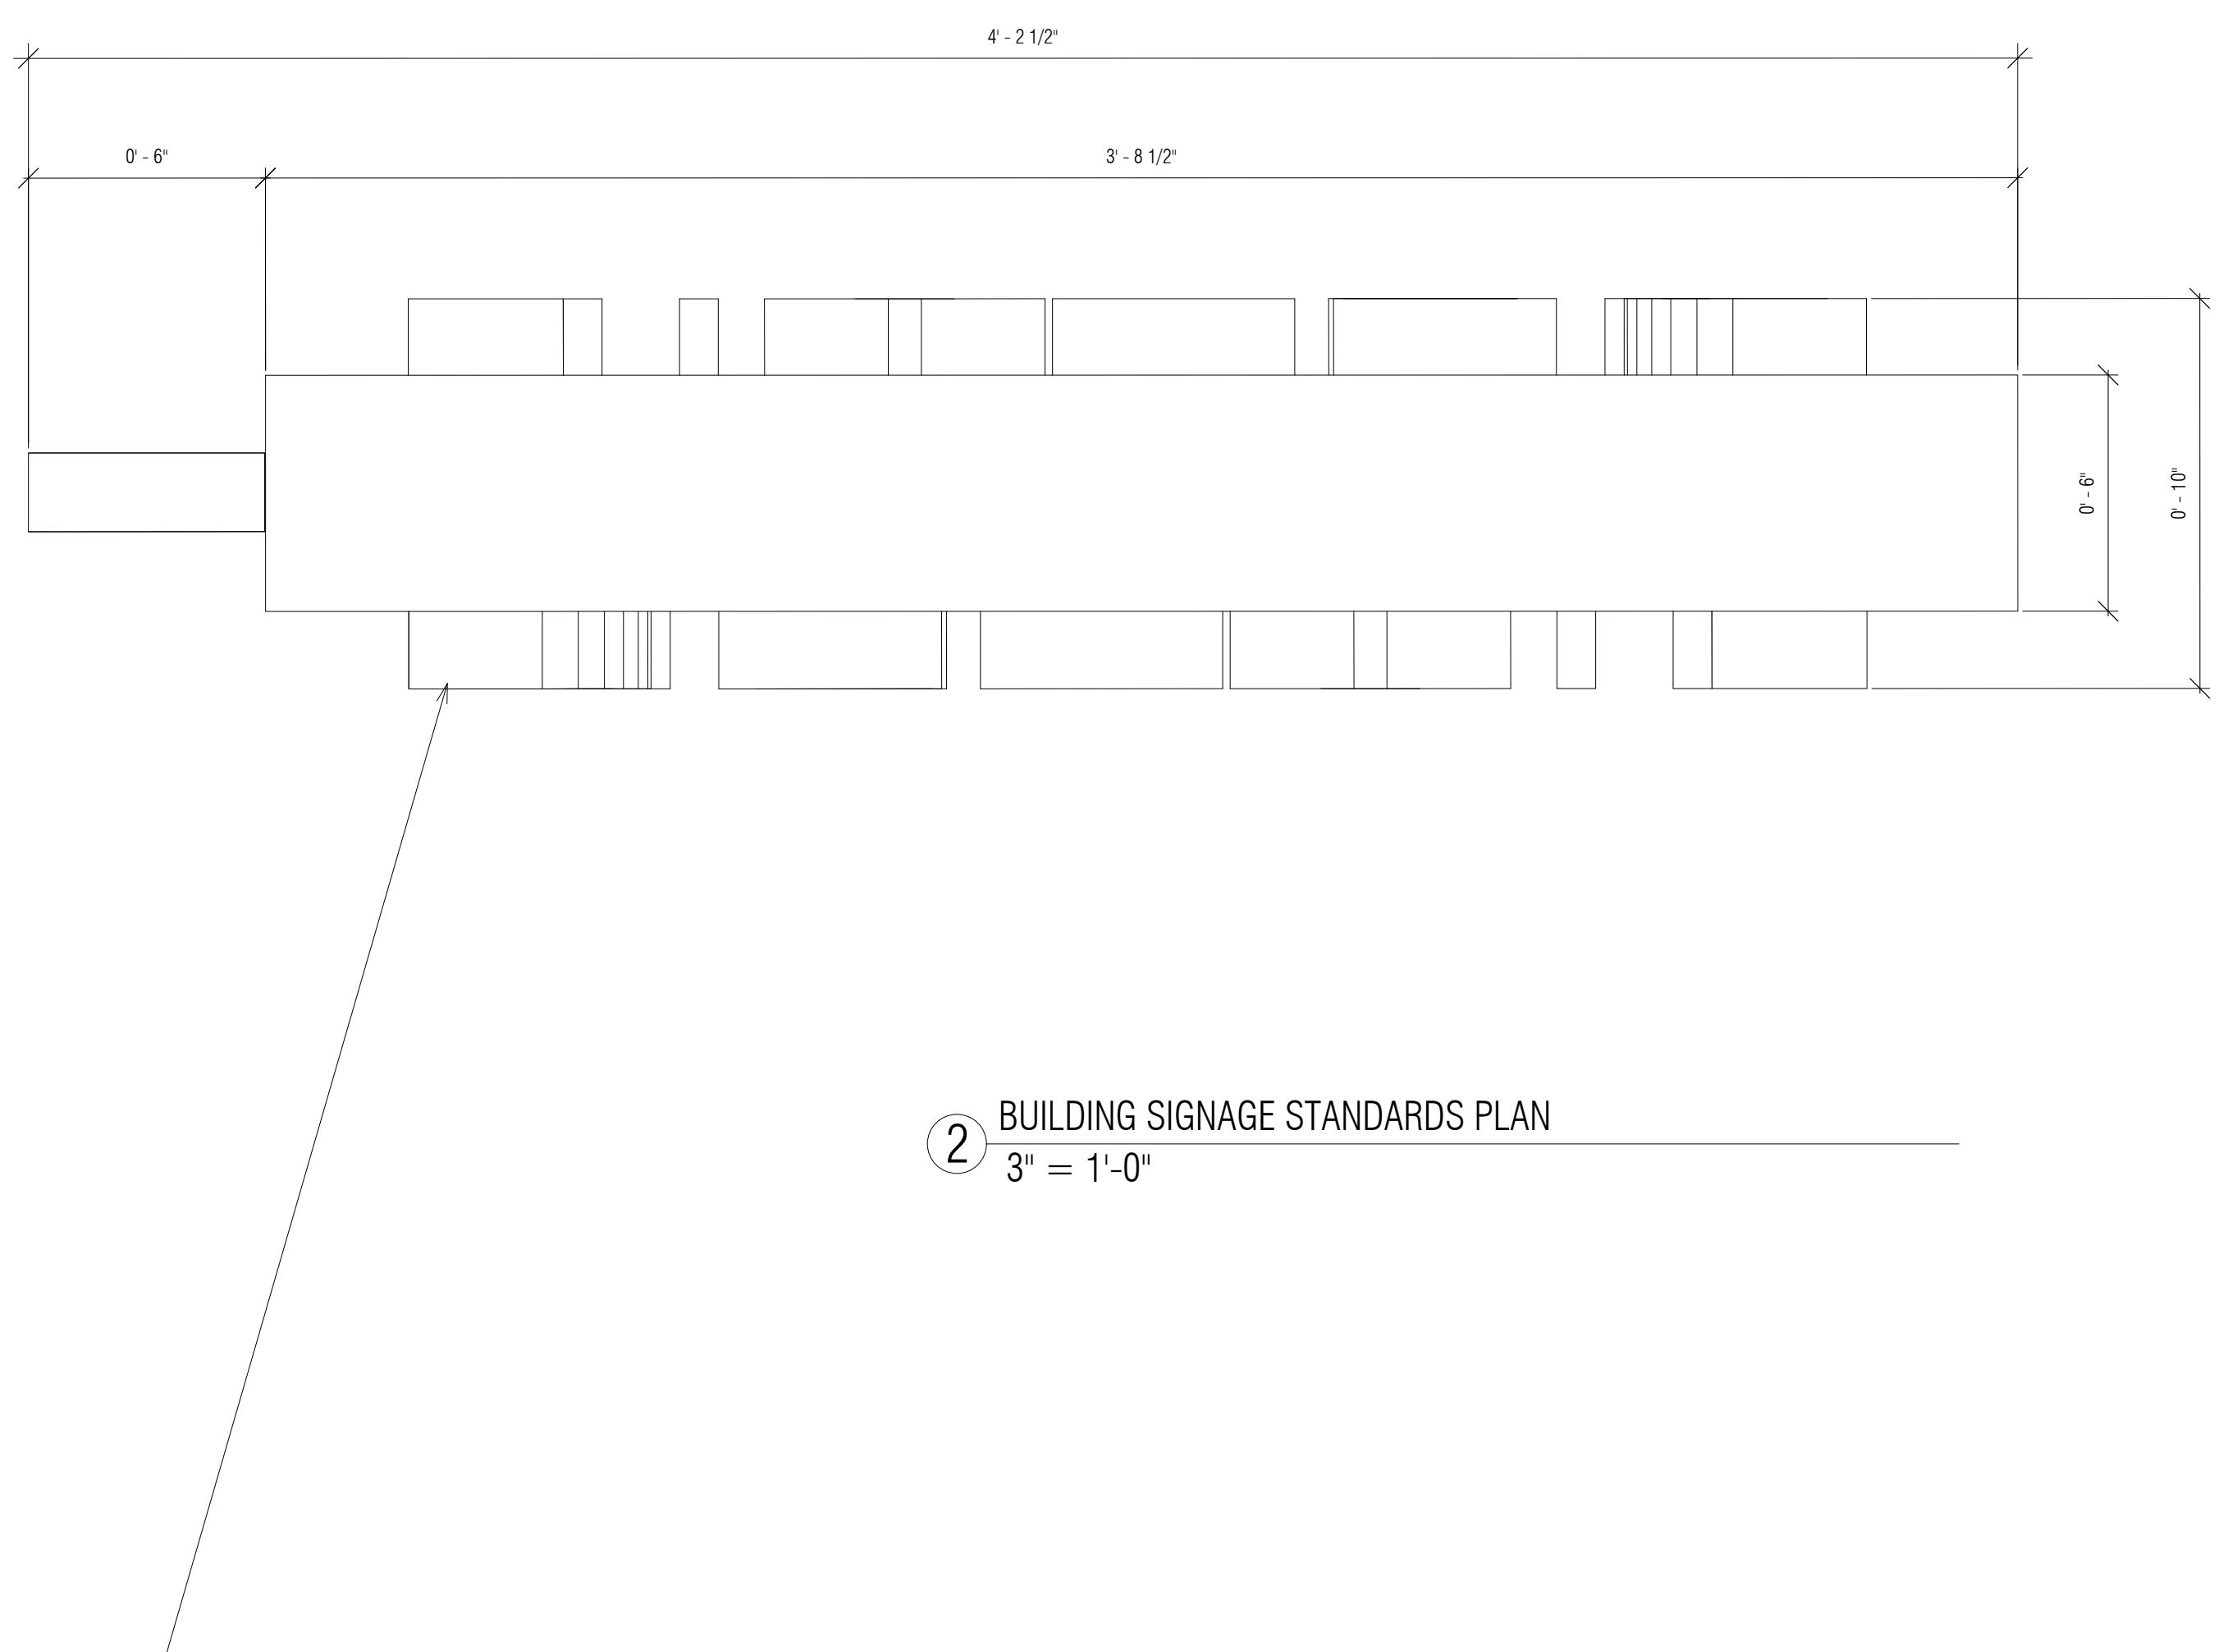

All drawings and written material appearing herein constitute original and unpublished work of Costa Brown Architecture, Inc. and may not be duplicated without the prior written consent of Costa Brown Architecture, Inc. © 2015.

Date: 04/14/2016

Scale: 3" = 1'-0"

Description:

**BUILDING  
SIGNAGE  
STANDARDS**

Sheet Number:

**A-8.5**